



ARCHICON

Architecture & Interiors, L.C.

5055 E WASHINGTON STREET
SUITE 200
PHOENIX, ARIZONA 85034
(602) 222-4266
FAX (602) 279-4305
www.ARCHICON.COM

NEW TERRIBLE'S COMMERCIAL DEVELOPMENT
FUEL STATION, CONVENIENCE STORE & CAR WASH
17973 N. PORTER ROAD
MARICOPA, AZ 85138

PROJECT NUMBER: 2428110-07
PROJECT MANAGER: MDM
DRAWN BY: MDM
CHECKED BY: JP

1	CITY COMMENTS	25.6.9



SHEET DESCRIPTION
C-STORE FLOOR PLAN



SHEET NO.

DR200


ISSUE DATE:

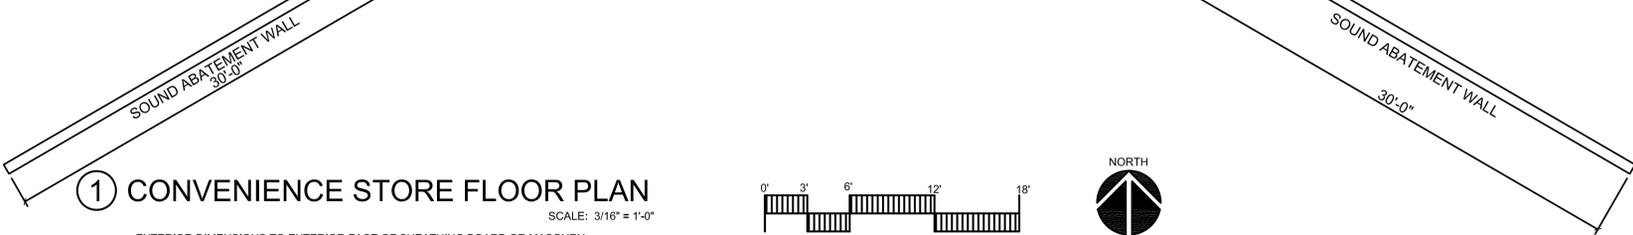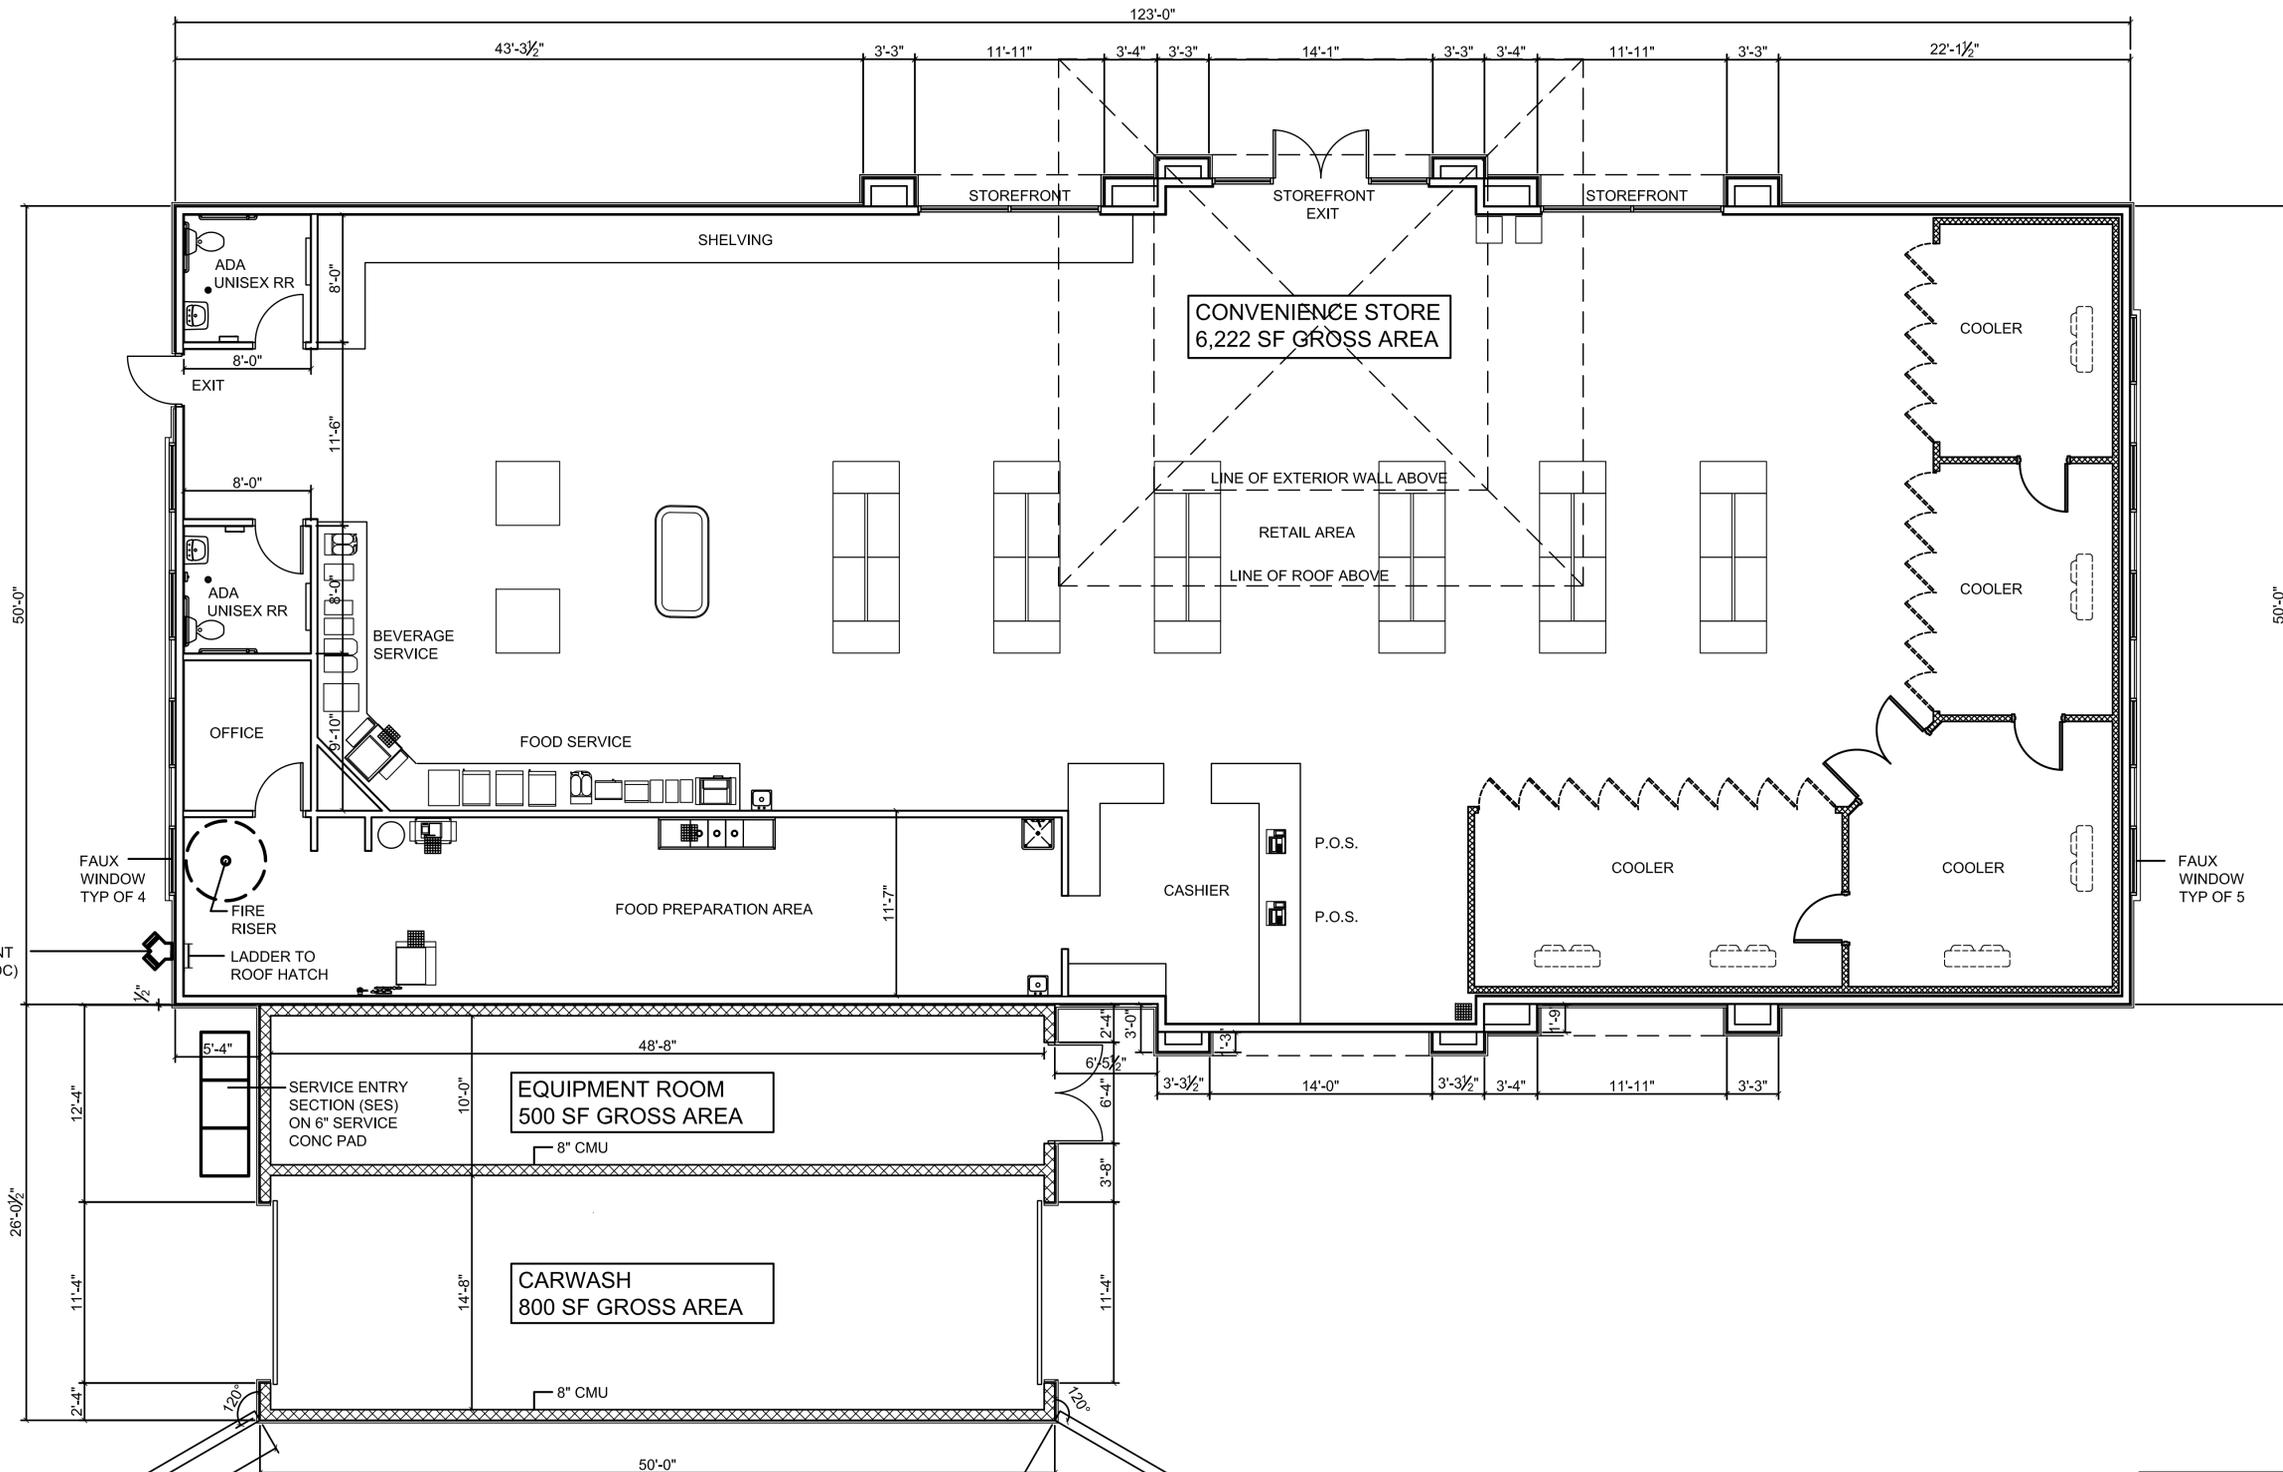

1 CONVENIENCE STORE FLOOR PLAN


SCALE: 3/16" = 1'-0"

 EXTERIOR DIMENSIONS TO EXTERIOR FACE OF SHEATHING BOARD OR MASONRY
INTERIOR DIMENSIONS TO FACE OF GYPSUM BOARD



APPROVALS

THIS DRAWING IS AN INSTRUMENT OF SERVICE AND THE PROPERTY OF ARCHICON ARCHITECTURE & INTERIORS, L.C. AND SHALL REMAIN THEIR PROPERTY. THE USE OF THIS DRAWING SHALL BE RESTRICTED TO THE ORIGINAL USE FOR WHICH IT WAS PREPARED AND NO REPRODUCTION THEREOF IS EXPRESSLY LIMITED TO SUCH.

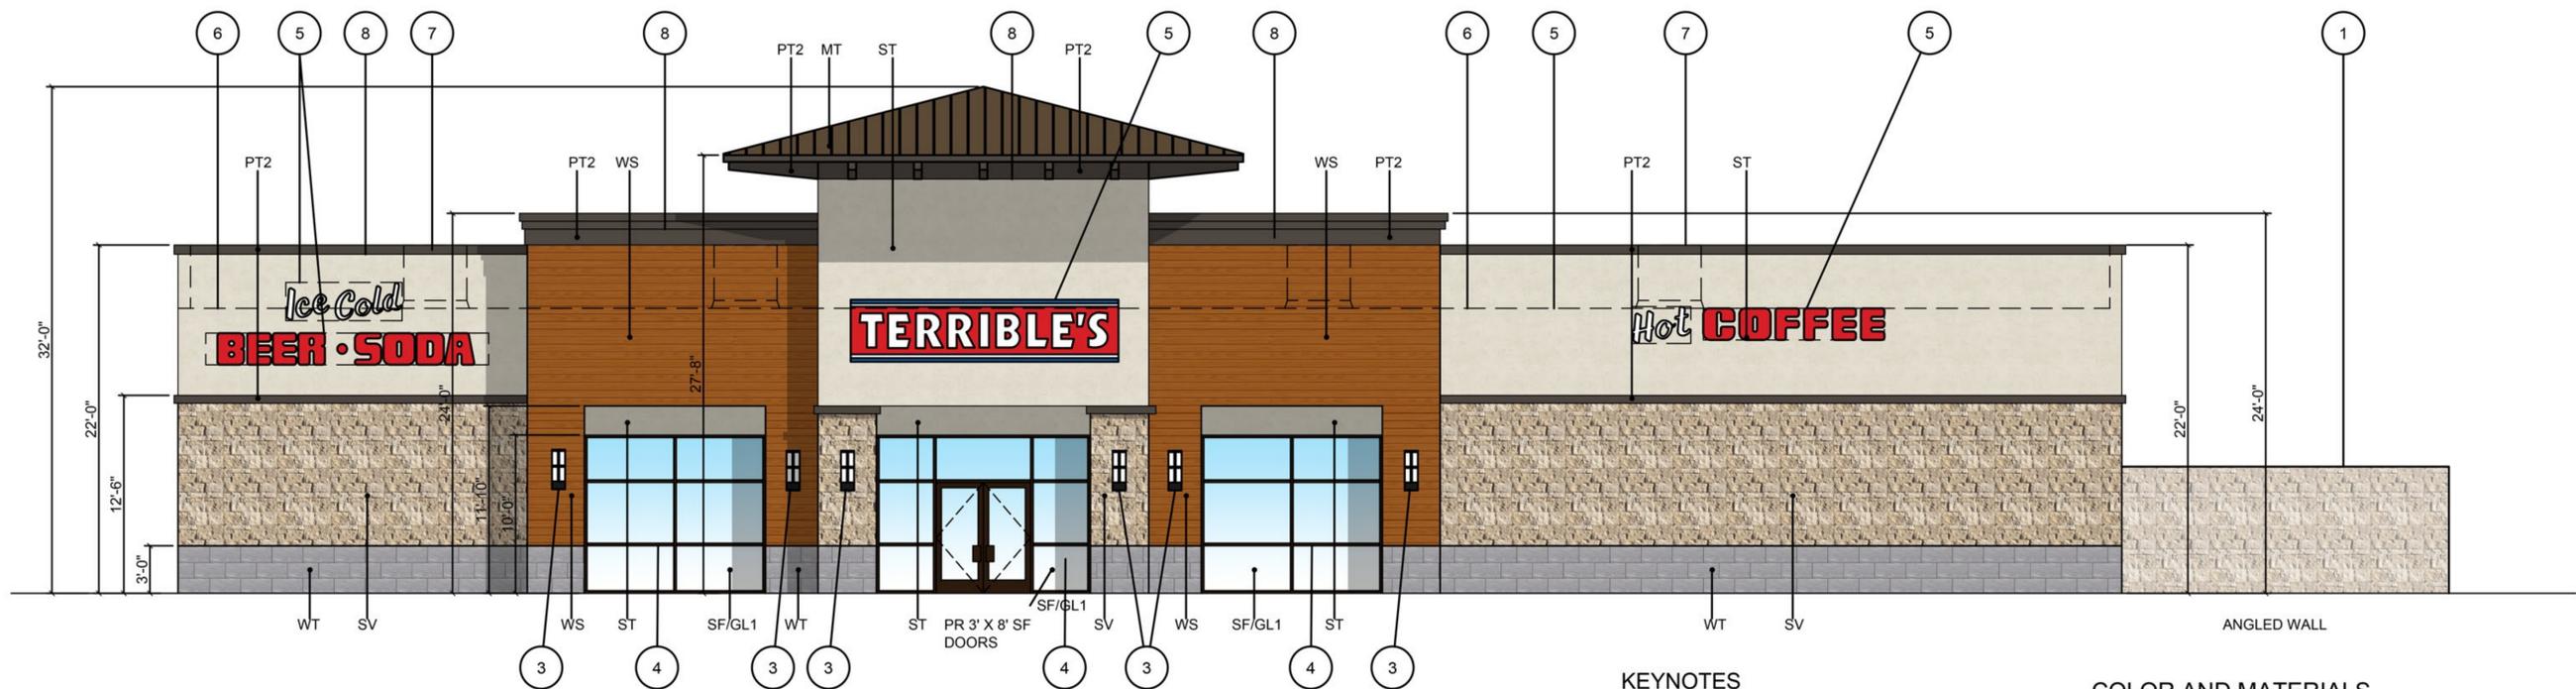

① NORTH ELEVATION


SCALE: 3/16" = 1'-0"

KEYNOTES

- 1 SOUND ABATEMENT WALL, 8'-0" HIGH
- 2 INSULATED HOLLOW METAL DOOR AND FRAME
- 3 LED LIGHT FIXTURE SURFACE MOUNTED
- 4 ALUMINUM STOREFRONT WITH INSULATED GLAZING
- 5 SIGNAGE UNDER SEPARATE PERMIT
- 6 ROOF LINE (DASHED)
- 7 MECHANICAL UNIT (DASHED) FULLY SCREENED
- 8 LED LIGHT FIXTURE LOCATED ON SOFFIT BELOW PARAPET

COLOR AND MATERIALS

- ST** 7/8" STUCCO FINISH ON SELF FURRING GALV. METAL LATH WITH FRY REGLET CORNERS, MOLDING AND TRIM.
COLOR: SW 6098 PACER WHITE
FINISH: FLAT FINISH
MANUF: SHERWIN WILLIAMS
- WS** WOOD SIDING (ALLURA CEMENT FIBERBOARD)
8" LAP SIDING, TEXTURED
COLOR: ARMORSHHELL, MAPLE T.S.
MANUF: NORTHWEST
- MT** METAL ROOFING STANDING SEAM
COLOR: MEDIUM BRONZE
MANUF: BERRIDGE OR EQUAL
- PT1** PAINT
COLOR: SW 6098 PACER WHITE
FINISH: SATIN
MANUF: SHERWIN WILLIAMS
- PT2** PAINT
COLOR: SW 7020 BLACK FOX
FINISH: FLAT
MANUF: SHERWIN WILLIAMS
- SV** STONE VENEER
TYPE: STACKED STONE CUT COURSE
COLOR: SEASHELL
MANUF: EL DORADO STONE
- WT** PORCELAIN WALL TILE
TYPE: PORCELAIN 12" X 24" AMBASSADOR
COLOR: GLOBAL GREY AM35 MATTE WITH MAPEI GROUT 112 MEDIUM GREY
MANUF: DAL TILE
- SF/GL** STOREFRONT
SF - ARCADIA ALUMINUM AFG451T MEDIUM STILE DARK BRONZE
GL1 - VITRO SOLARBAN 90 (2) CLEAR + CLEAR 1" INSULATING GLASS UNIT, 51% VLT, 12% EXT. REFL., 19% INT. REFL., 0.24 U-VALUE (ARGON), 0.23 SHGS, 2.22 LSG
GL2 - VITRO SPANDREL GLASS

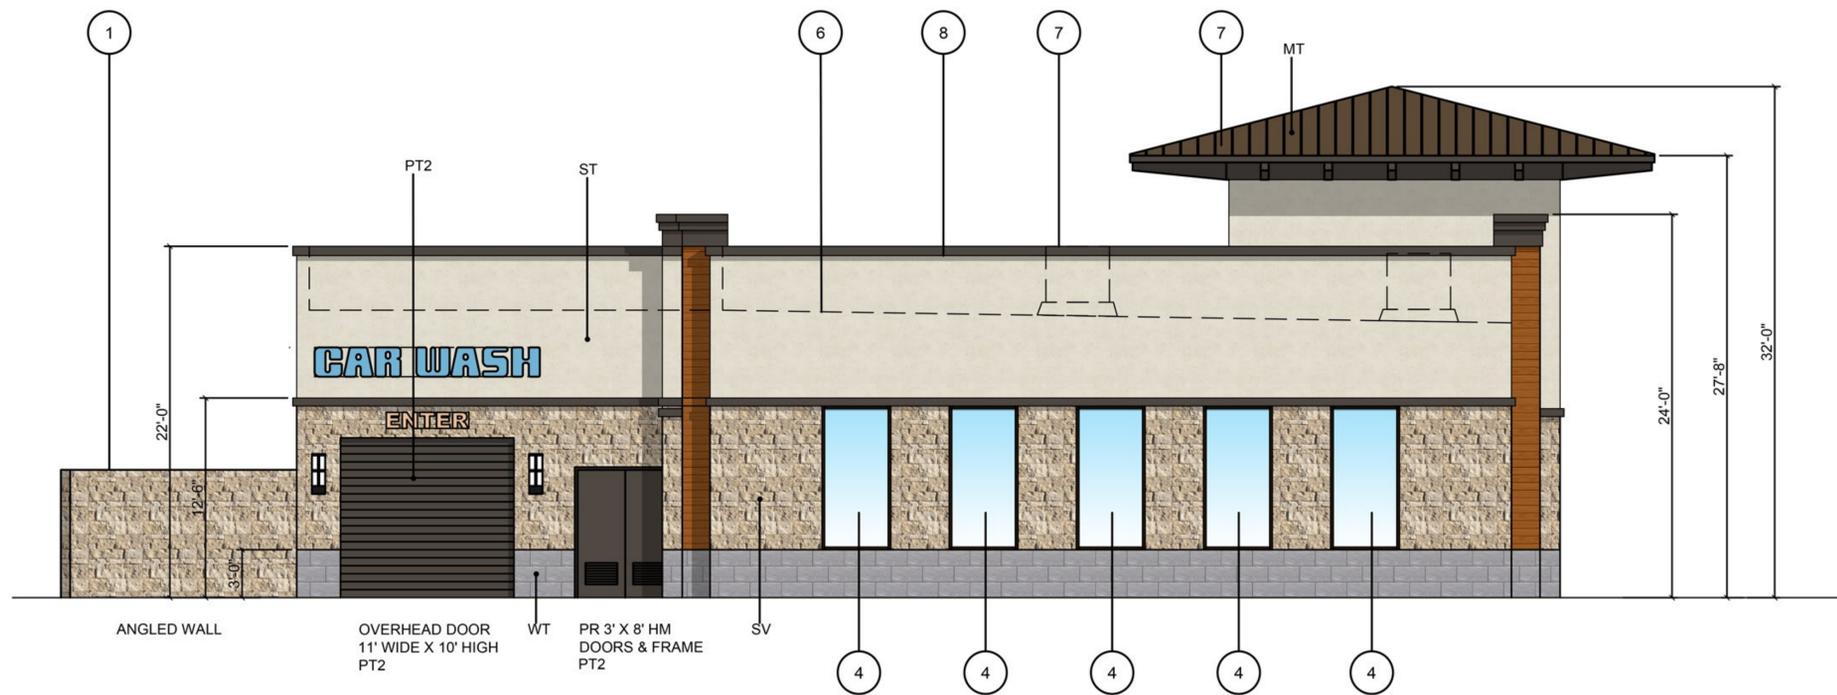

② EAST ELEVATION

SCALE: 3/16" = 1'-0"

ARCHICON
Architecture & Interiors, L.C.
5055 E WASHINGTON STREET
SUITE 200
PHOENIX, ARIZONA 85034
(602) 222-4266
FAX (602) 279-4305
WWW.ARCHICON.COM

NEW TERRIBLE'S COMMERCIAL DEVELOPMENT
FUEL STATION, CONVENIENCE STORE & CAR WASH
17973 N. PORTER ROAD
MARICOPA, AZ 85138

PROJECT NUMBER: 2428110-07
PROJECT MANAGER: MDM
DRAWN BY: MDM
CHECKED BY: JP

1	CITY COMMENTS	25.6.9

SHEET DESCRIPTION
N & E EXTERIOR
ELEVATIONS COLORED




SHEET NO.

DR300C

ISSUE DATE:

APPROVALS

THIS DRAWING IS AN INSTRUMENT OF SERVICE AND THE PROPERTY OF ARCHICON ARCHITECTURE & INTERIORS, L.C. AND SHALL REMAIN THEIR PROPERTY. THE USE OF THIS DRAWING SHALL BE RESTRICTED TO THE ORIGINAL USE FOR WHICH IT WAS PREPARED AND PUBLICATION THEREOF IS EXPRESSLY LIMITED TO SUCH.

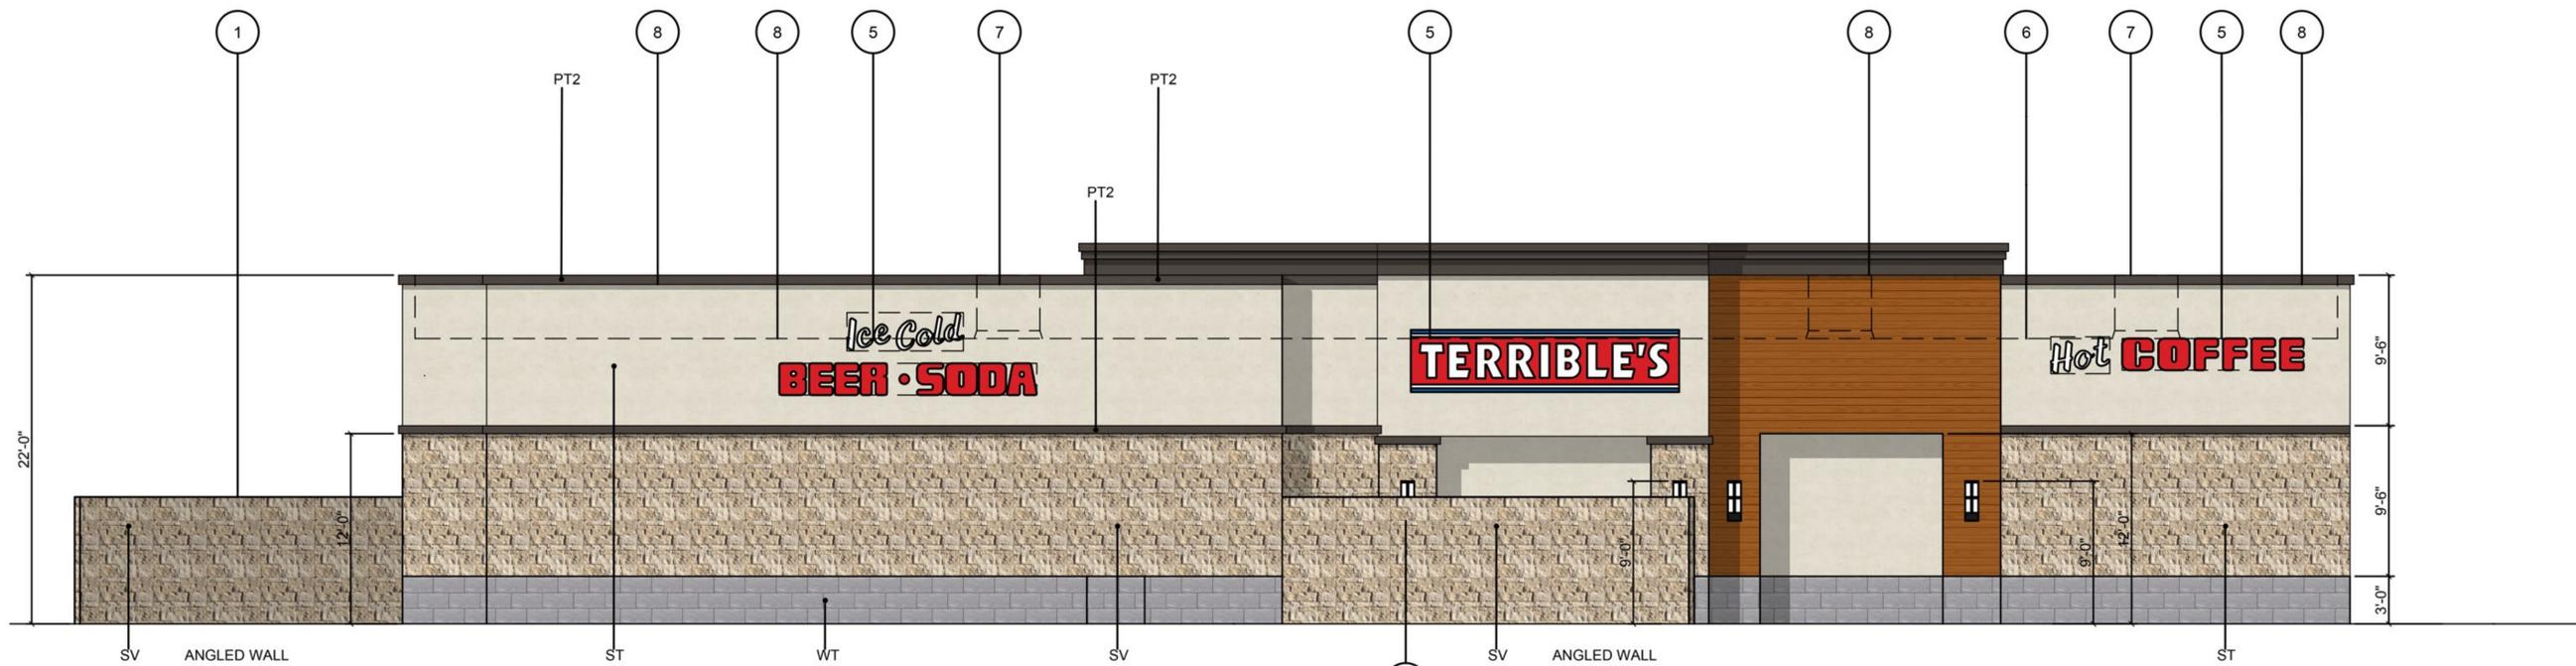

③ SOUTH ELEVATION


SCALE: 3/16" = 1'-0"

KEYNOTES

- 1 SOUND ABATEMENT WALL, 8'-0" HIGH
- 2 INSULATED HOLLOW METAL DOOR AND FRAME
- 3 LED LIGHT FIXTURE SURFACE MOUNTED
- 4 ALUMINUM STOREFRONT WITH INSULATED GLAZING
- 5 SIGNAGE UNDER SEPARATE PERMIT
- 6 ROOF LINE (DASHED)
- 7 MECHANICAL UNIT (DASHED) FULLY SCREENED
- 8 LED LIGHT FIXTURE LOCATED ON SOFFIT BELOW PARAPET

COLOR AND MATERIALS

- ST** 7/8" STUCCO FINISH ON SELF FURRING GALV. METAL LATH WITH FRY REGLET CORNERS, MOLDING AND TRIM.
COLOR: SW 6098 PACER WHITE
FINISH: FLAT FINISH
MANUF: SHERWIN WILLIAMS
- WS** WOOD SIDING (ALLURA CEMENT FIBERBOARD) 8" LAP SIDING, TEXTURED
COLOR: ARMORSHHELL, MAPLE T.S.
MANUF: NORTHWEST
- MT** METAL ROOFING STANDING SEAM
COLOR: MEDIUM BRONZE
MANUF: BERRIDGE OR EQUAL
- PT1** PAINT
COLOR: SW 6098 PACER WHITE
FINISH: SATIN
MANUF: SHERWIN WILLIAMS
- PT2** PAINT
COLOR: SW 7020 BLACK FOX
FINISH: FLAT
MANUF: SHERWIN WILLIAMS
- SV** STONE VENEER
TYPE: STACKED STONE CUT COURSE
COLOR: SEASHELL
MANUF: EL DORADO STONE
- WT** PORCELAIN WALL TILE
TYPE: PORCELAIN 12" X 24" AMBASSADOR
COLOR: GLOBAL GREY AM35 MATTE WITH MAPEI GROUT 112 MEDIUM GREY
MANUF: DAL TILE
- SF/GL** STOREFRONT
SF - ARCADIA ALUMINUM AFG451T MEDIUM STILE DARK BRONZE
GL1 - VITRO SOLARBAN 90 (2) CLEAR + CLEAR 1" INSULATING GLASS UNIT, 51% VLT, 12% EXT. REFL., 19% INT. REFL., 0.24 U-VALUE (ARGON), 0.23 SHGS, 2.22 LSG
GL2 - VITRO SPANDREL GLASS

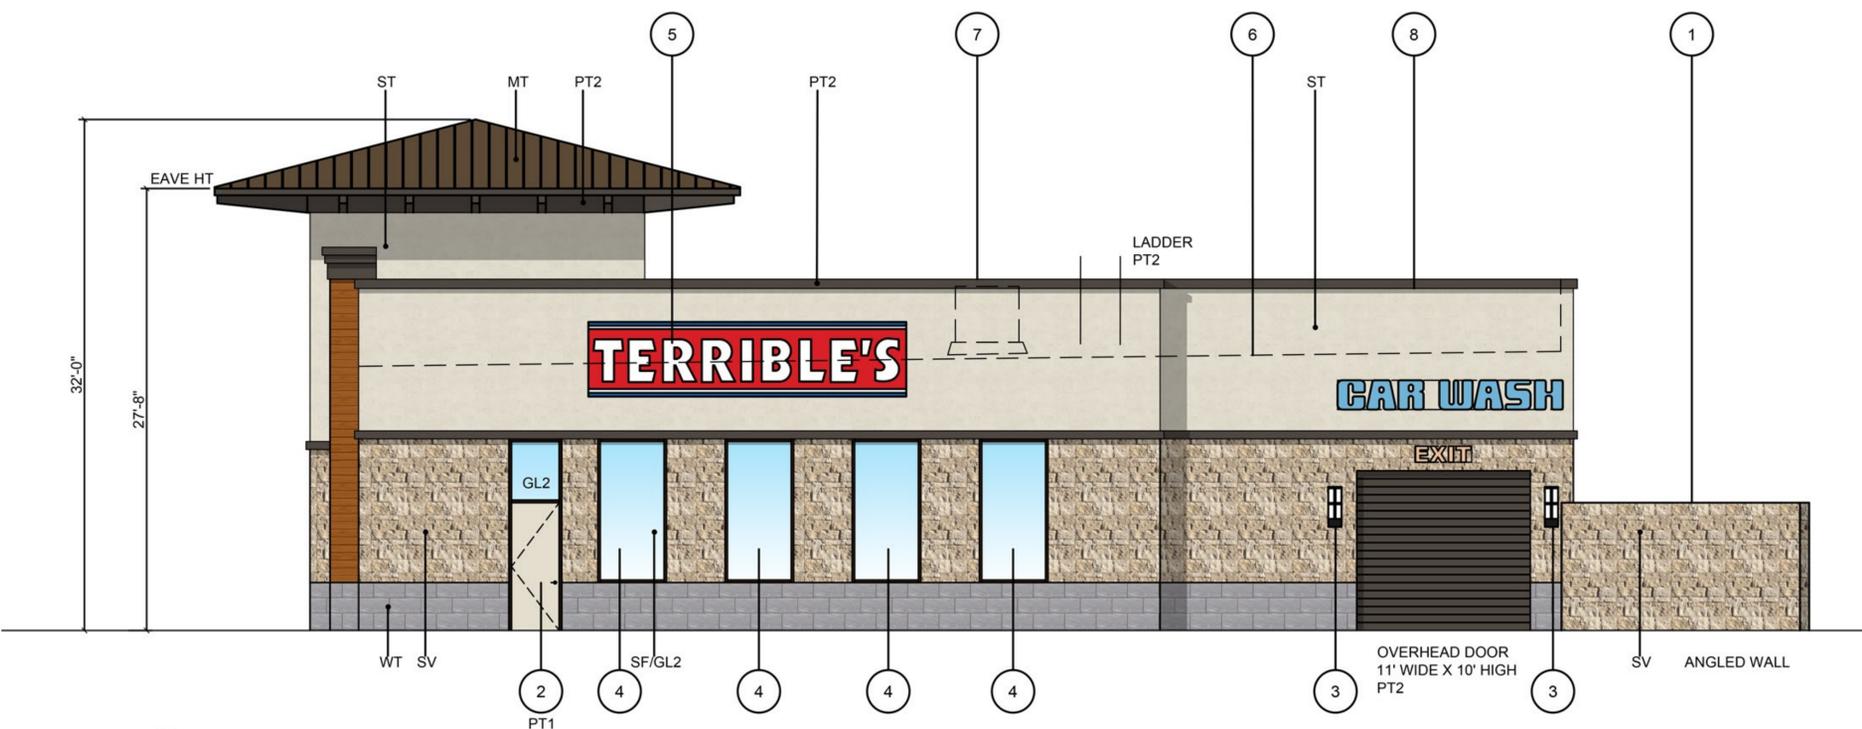

④ WEST ELEVATION

SCALE: 3/16" = 1'-0"

PROJECT NUMBER:	2428110-07
PROJECT MANAGER:	MDM
DRAWN BY:	MDM
CHECKED BY:	JP

1	CITY COMMENTS	25.6.9

SHEET DESCRIPTION
S & W EXTERIOR
ELEVATIONS COLORED




SHEET NO.


DR301C

ISSUE DATE: 25.2.20


THIS DRAWING IS AN INSTRUMENT OF SERVICE AND THE PROPERTY OF ARCHICON ARCHITECTURE & INTERIORS, L.C. AND SHALL REMAIN THEIR PROPERTY. THE USE OF THIS DRAWING SHALL BE RESTRICTED TO THE ORIGINAL USE FOR WHICH IT WAS PREPARED AND NO REPRODUCTION OR PUBLICATION THEREOF IS EXPRESSLY LIMITED TO SUCH.

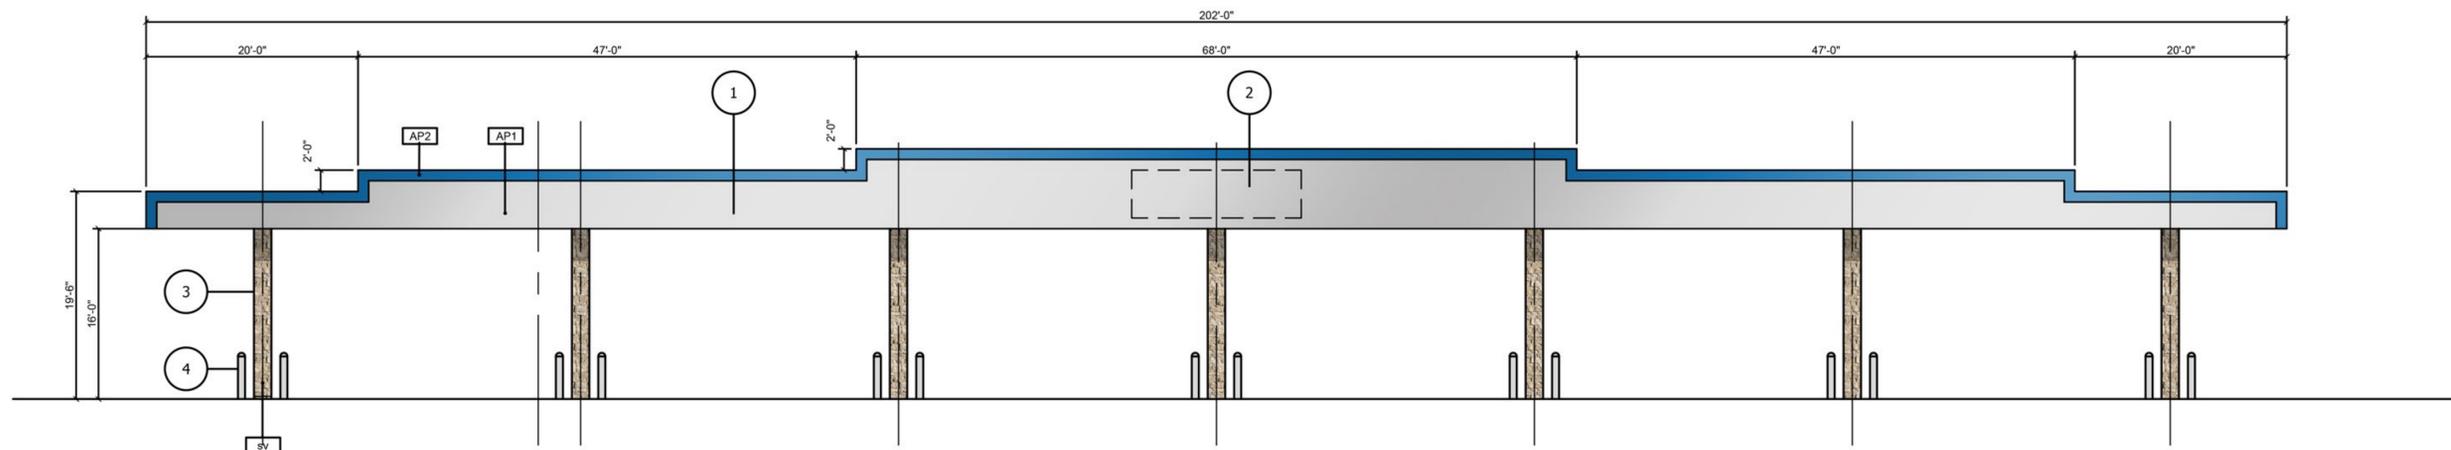


① EAST/WEST ELEVATION SCALE: 1/8" = 1'-0"

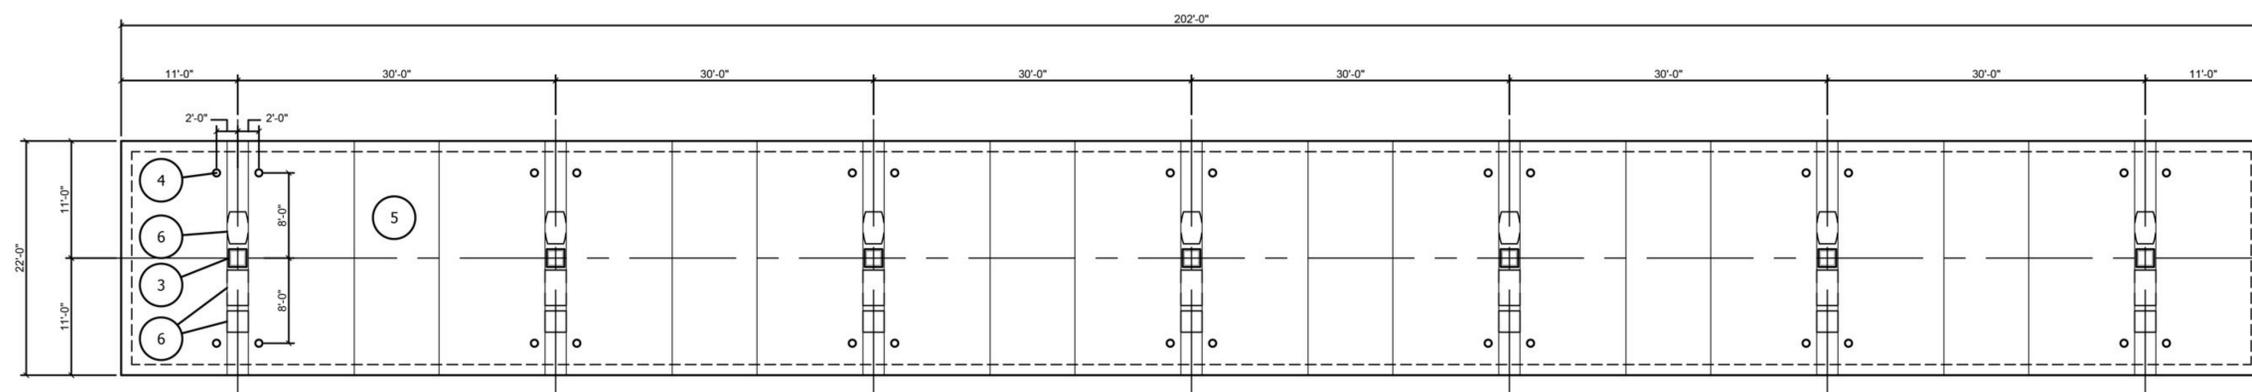

② FUEL STATION PLAN SCALE: 1/8" = 1'-0"

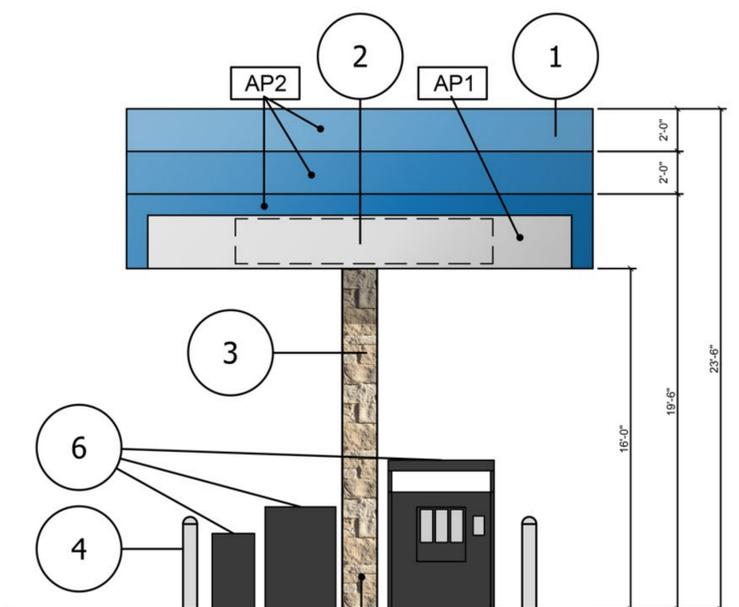

③ NORTH/SOUTH ELEVATION SCALE: 1/4" = 1'-0"

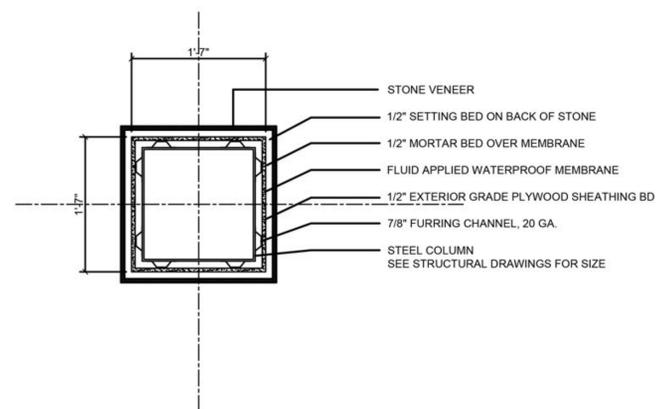

④ COLUMN DETAIL SCALE: 1/4" = 1'-0"

KEYNOTES

- 1 ACRYLIC CANOPY PANEL
- 2 SIGNAGE (UNDER SEPARATE PERMIT)
- 3 STEEL COLUMN COVERED WITH STONE VENEER
- 4 CONCRETE FILLED 8" DIA. STEEL BOLLARD, 4' HIGH PRIMED AND PAINTED WHITE
- 5 CONCRETE SLAB ON GRADE
- 6 GAS PUMPS/EQUIPMENT PER TENANT SPECIFICATIONS

COLOR AND MATERIALS

- AP1** ACRYLIC PANEL
COLOR: CHEVRON WHITE
- AP2** ACRYLIC PANEL
COLOR: CHEVRON BLUE
- PT2** PAINT
COLOR: BLACK FOX SW 7020
FINISH: SATIN
MANUF: SHERWIN WILLIAMS
- SV** STONE VENEER
TYPE: STACKED STONE CUT COURSE
COLOR: SEASHELL
MANUF: EL DORADO STONE

APPROVALS

ARCHICON
Architecture & Interiors, L.C.


5055 E WASHINGTON STREET
SUITE 200
PHOENIX, ARIZONA 85034
(602) 222-4266
FAX (602) 279-4305
www.ARCHICON.COM

NEW TERRIBLE'S COMMERCIAL DEVELOPMENT
FUEL STATION, CONVENIENCE STORE & CAR WASH
17973 N. PORTER ROAD
MARICOPA, AZ 85138

PROJECT NUMBER: 2428110-07
PROJECT MANAGER: MDM
DRAWN BY: MDM
CHECKED BY: JP

1	CITY COMMENTS	25.6.9

SHEET DESCRIPTION
FUEL CANOPY ELEVATIONS

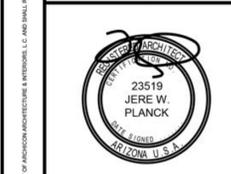

SHEET NO.
DR302C
ISSUE DATE:


Statistics						
Description	Symbol	Avg	Max	Min	Max/Min	Avg/Min
PROPERTY LINE - FC @ GRADE	✕	0.1 fc	0.5 fc	0.0 fc	N/A	N/A
SITE - FC @ GRADE	+	5.3 fc	70.1 fc	0.0 fc	N/A	N/A

Schedule										
Symbol	Label	Quantity	Manufacturer	Catalog Number	Description	Lamp	Lumens Per Lamp	Lumen Multiplier	Light Loss Factor	Wattage
○	S1	3	NLS LIGHTING	CAL-S (TOP) (SHADE) T5 32L 1 40K UNV AM (FINISH) / A14-S SGL 4R (FINISH) / RSS 11.5' W/2.5' BASE	BELL SHAPE AREA LUMINAIRE - TYPE 5 OPTIC	LED - 4000K	10919	1	0.91	106
○	S2	11	NLS LIGHTING	CAL-S (TOP) (SHADE) T4 32L 1 40K UNV AM (FINISH) / A14-S SGL 4R (FINISH) / RSS 11.5' W/2.5' BASE	BELL SHAPE AREA LUMINAIRE - TYPE 4 OPTIC	LED - 4000K	11307	1	0.91	106
○	SA	5	NLS LIGHTING	CAL-S (TOP) (SHADE) T3 16L 7 40K UNV WM (FINISH)	BELL SHAPE WALL MOUNT - TYPE 3 OPTIC	LED - 4000K	3810	1	0.91	36
○	SB	2	NLS LIGHTING	CAL-S (TOP) (SHADE) T4 16L 7 40K UNV WM (FINISH)	BELL SHAPE WALL MOUNT - TYPE 4 OPTIC	LED - 4000K	3840	1	0.91	36
○	SC	2	LITHONIA	LDN6 40/20 L06AR LSS MVOLT GZ10	6" RECESSED DOWNLIGHT	LED - 4000K	2009	1	0.91	22.52
○	SCE	2	LITHONIA	LDN6 40/20 L06AR LSS MVOLT GZ10 EL	6" RECESSED DOWNLIGHT W/EM BATTERY PACK	LED - 4000K	2009	1	0.91	22.52
□	SD	10	MODERN FORMS	WS-W5411-BK	STRUCTURE DECORATIVE WALL MOUNT	LED - 3000K	528	1	0.91	10.7
□	SF	28	LSI INDUSTRIES	CRUS-SCFT-LED-VHO-40	GAS PAD LED CANOPY	LED - 4000K	22602	1	0.91	152
—	SG-48	2	LSI INDUSTRIES	ARCH-29-5-LED-BW-MULTI-FIELD (CHANNEL) / (POWER SUPPLY)	48" UNIFORM OUTDOOR TAPE LIGHT (VERIFY LENGTH PRIOR TO ORDERING)	LED - 4000K	750	1	0.91	648.4802
—	SG-122	2	LSI INDUSTRIES	ARCH-29-5-LED-BW-MULTI-FIELD (CHANNEL) / (POWER SUPPLY)	122" UNIFORM OUTDOOR TAPE LIGHT (VERIFY LENGTH PRIOR TO ORDERING)	LED - 4000K	750	1	0.91	1648.221
○	SH	5	NLS LIGHTING	ORX-B 42 T3 16L 53 40K8 UNV AB (FINISH)	BOLLARD - TYPE 3	LED - 4000K	2343	1	0.91	28
—	VAC	3	TARGETTI	DL HV 37 O 40 (END PREP CONNECTION) (MOUNTING)	8" LINE VOLTAGE STRIP LIGHT MOUNTED @ 12"-0"	LED - 4000K	1150	1	0.91	14.8

WEST BOWLIN ROAD

NORTH PORTER ROAD

(PUBLIC ROADWAY)

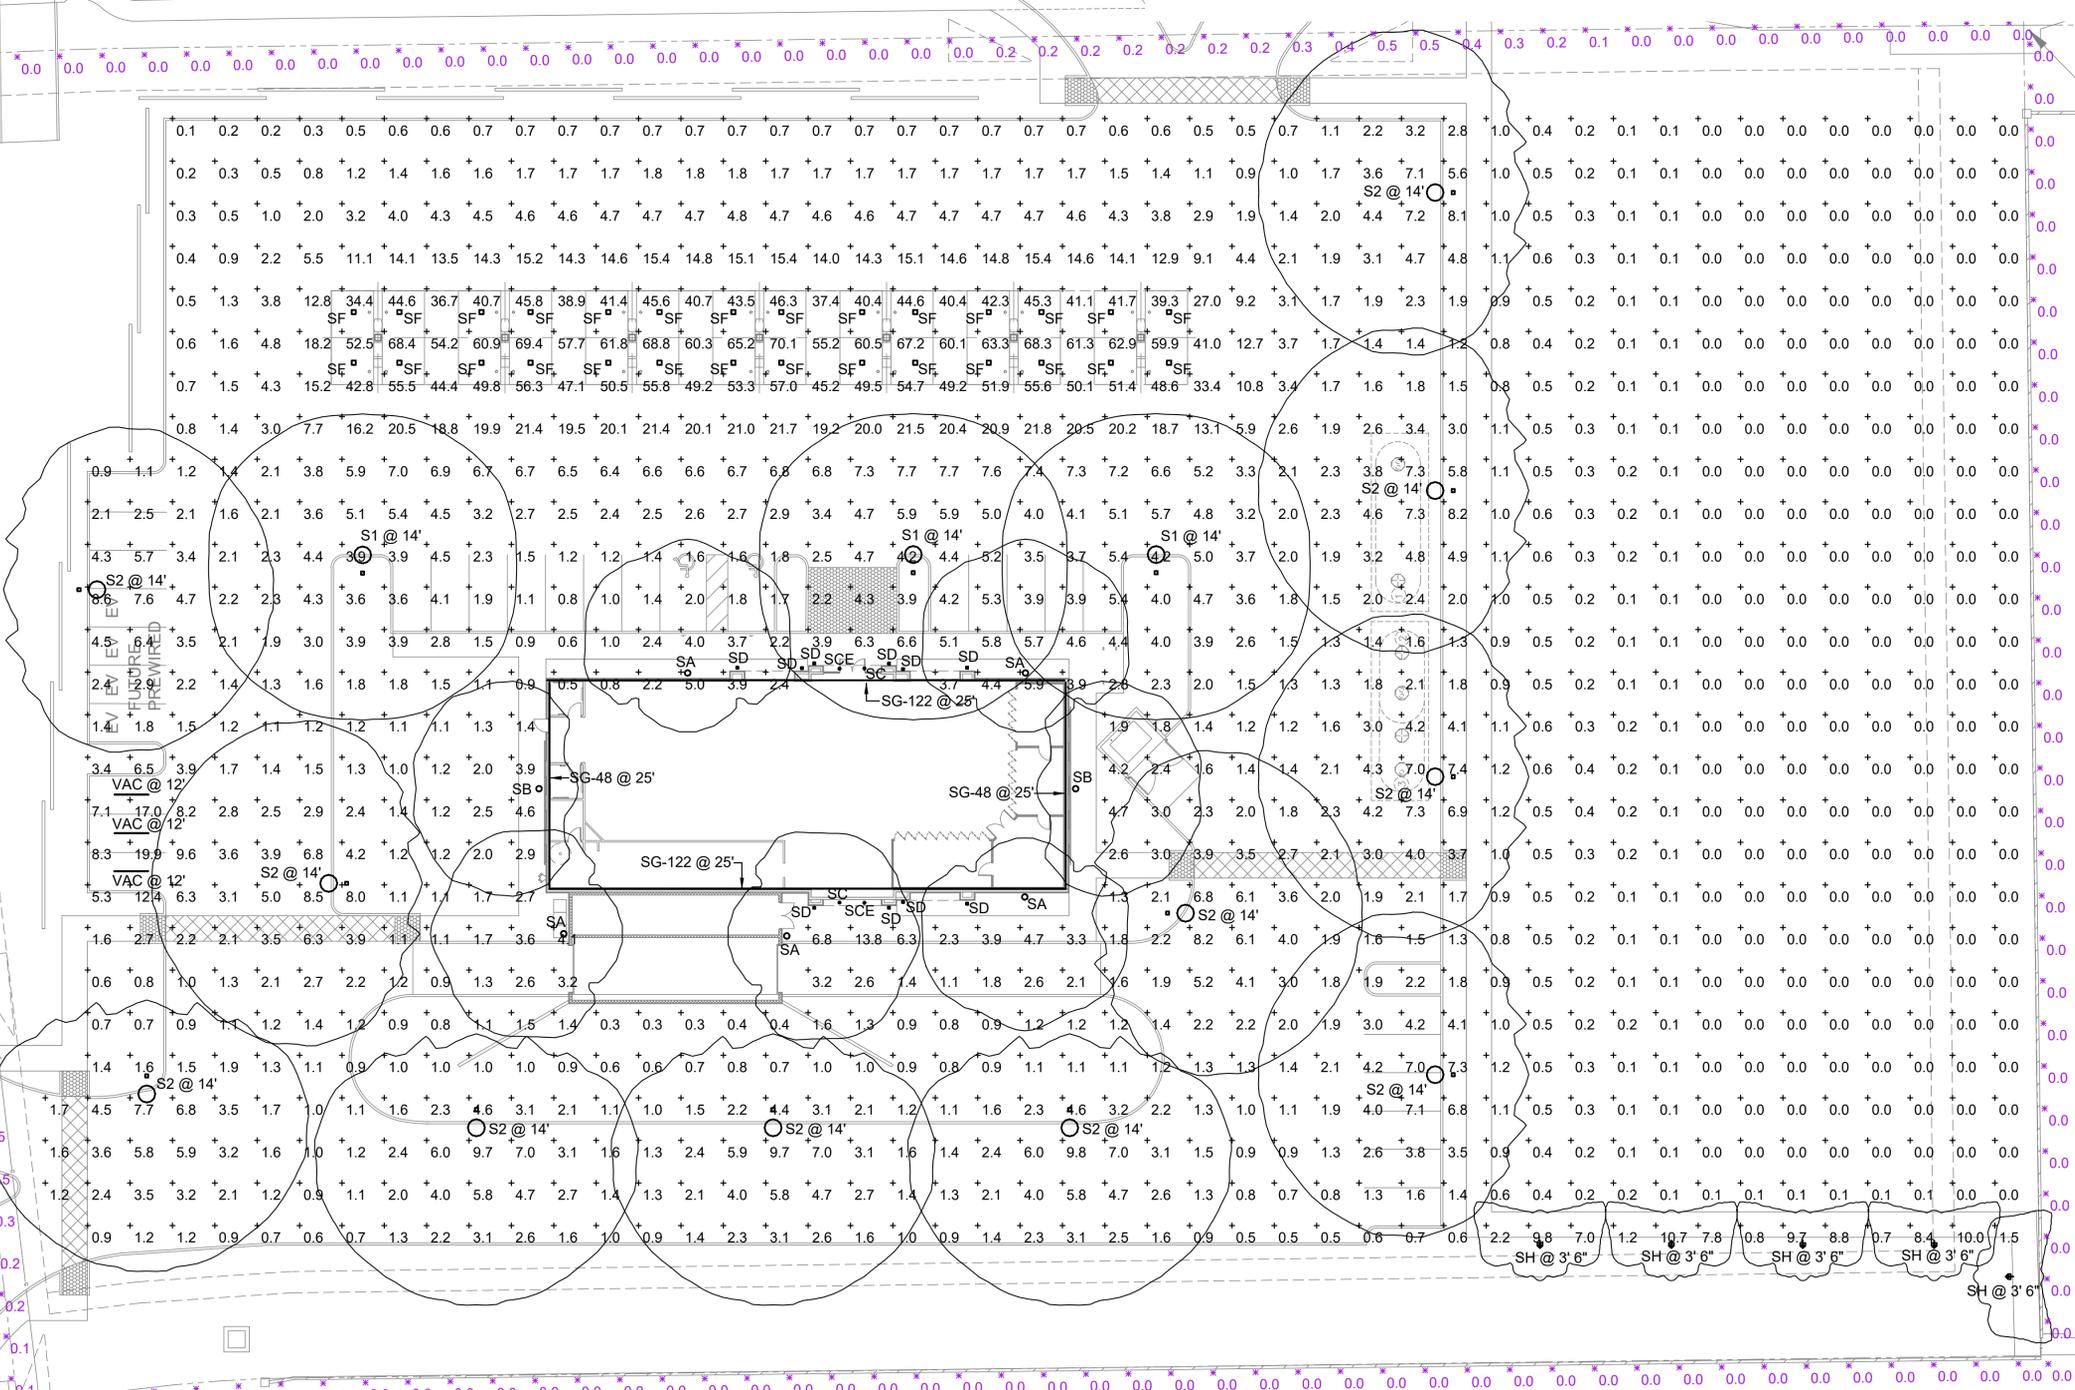

PHOTOMETRIC PLAN
1"=20'-0"

ASEIENGINEERING
7320 W. Asteron Ln. Suite 43, Phoenix, AZ 85021
Phone: 602.287.7000 | Fax: 602.287.7000
www.aseiengineering.com | Email: info@aseiengineering.com
DATE: 08/14/2024
DRAWN BY: MDM
CHECKED BY: JP

ARCHICON
Architecture & Interiors, L.C.
5055 E WASHINGTON STREET
SUITE 200
PHOENIX, ARIZONA 85034
(602) 222-4266
FAX (602) 279-4305
www.ARCHICON.COM

**NEW RETAIL DEVELOPMENT
TERRIBLE'S C-STORE
SEC N. PORTER & W. BOWLIN ROADS
MARICOPA, AZ 85138**

PROJECT NUMBER: 2428110-07
PROJECT MANAGER: MDM
DRAWN BY: MDM
CHECKED BY: JP

SHEET DESCRIPTION
PHOTOMETRIC PLAN

FOR
INFORMATION
ONLY

SHEET NO.

PH-1

ISSUE DATE: 24.12.4

