


# Tractor Supply Co - Maricopa, AZ Parking Lot Lighting Layout

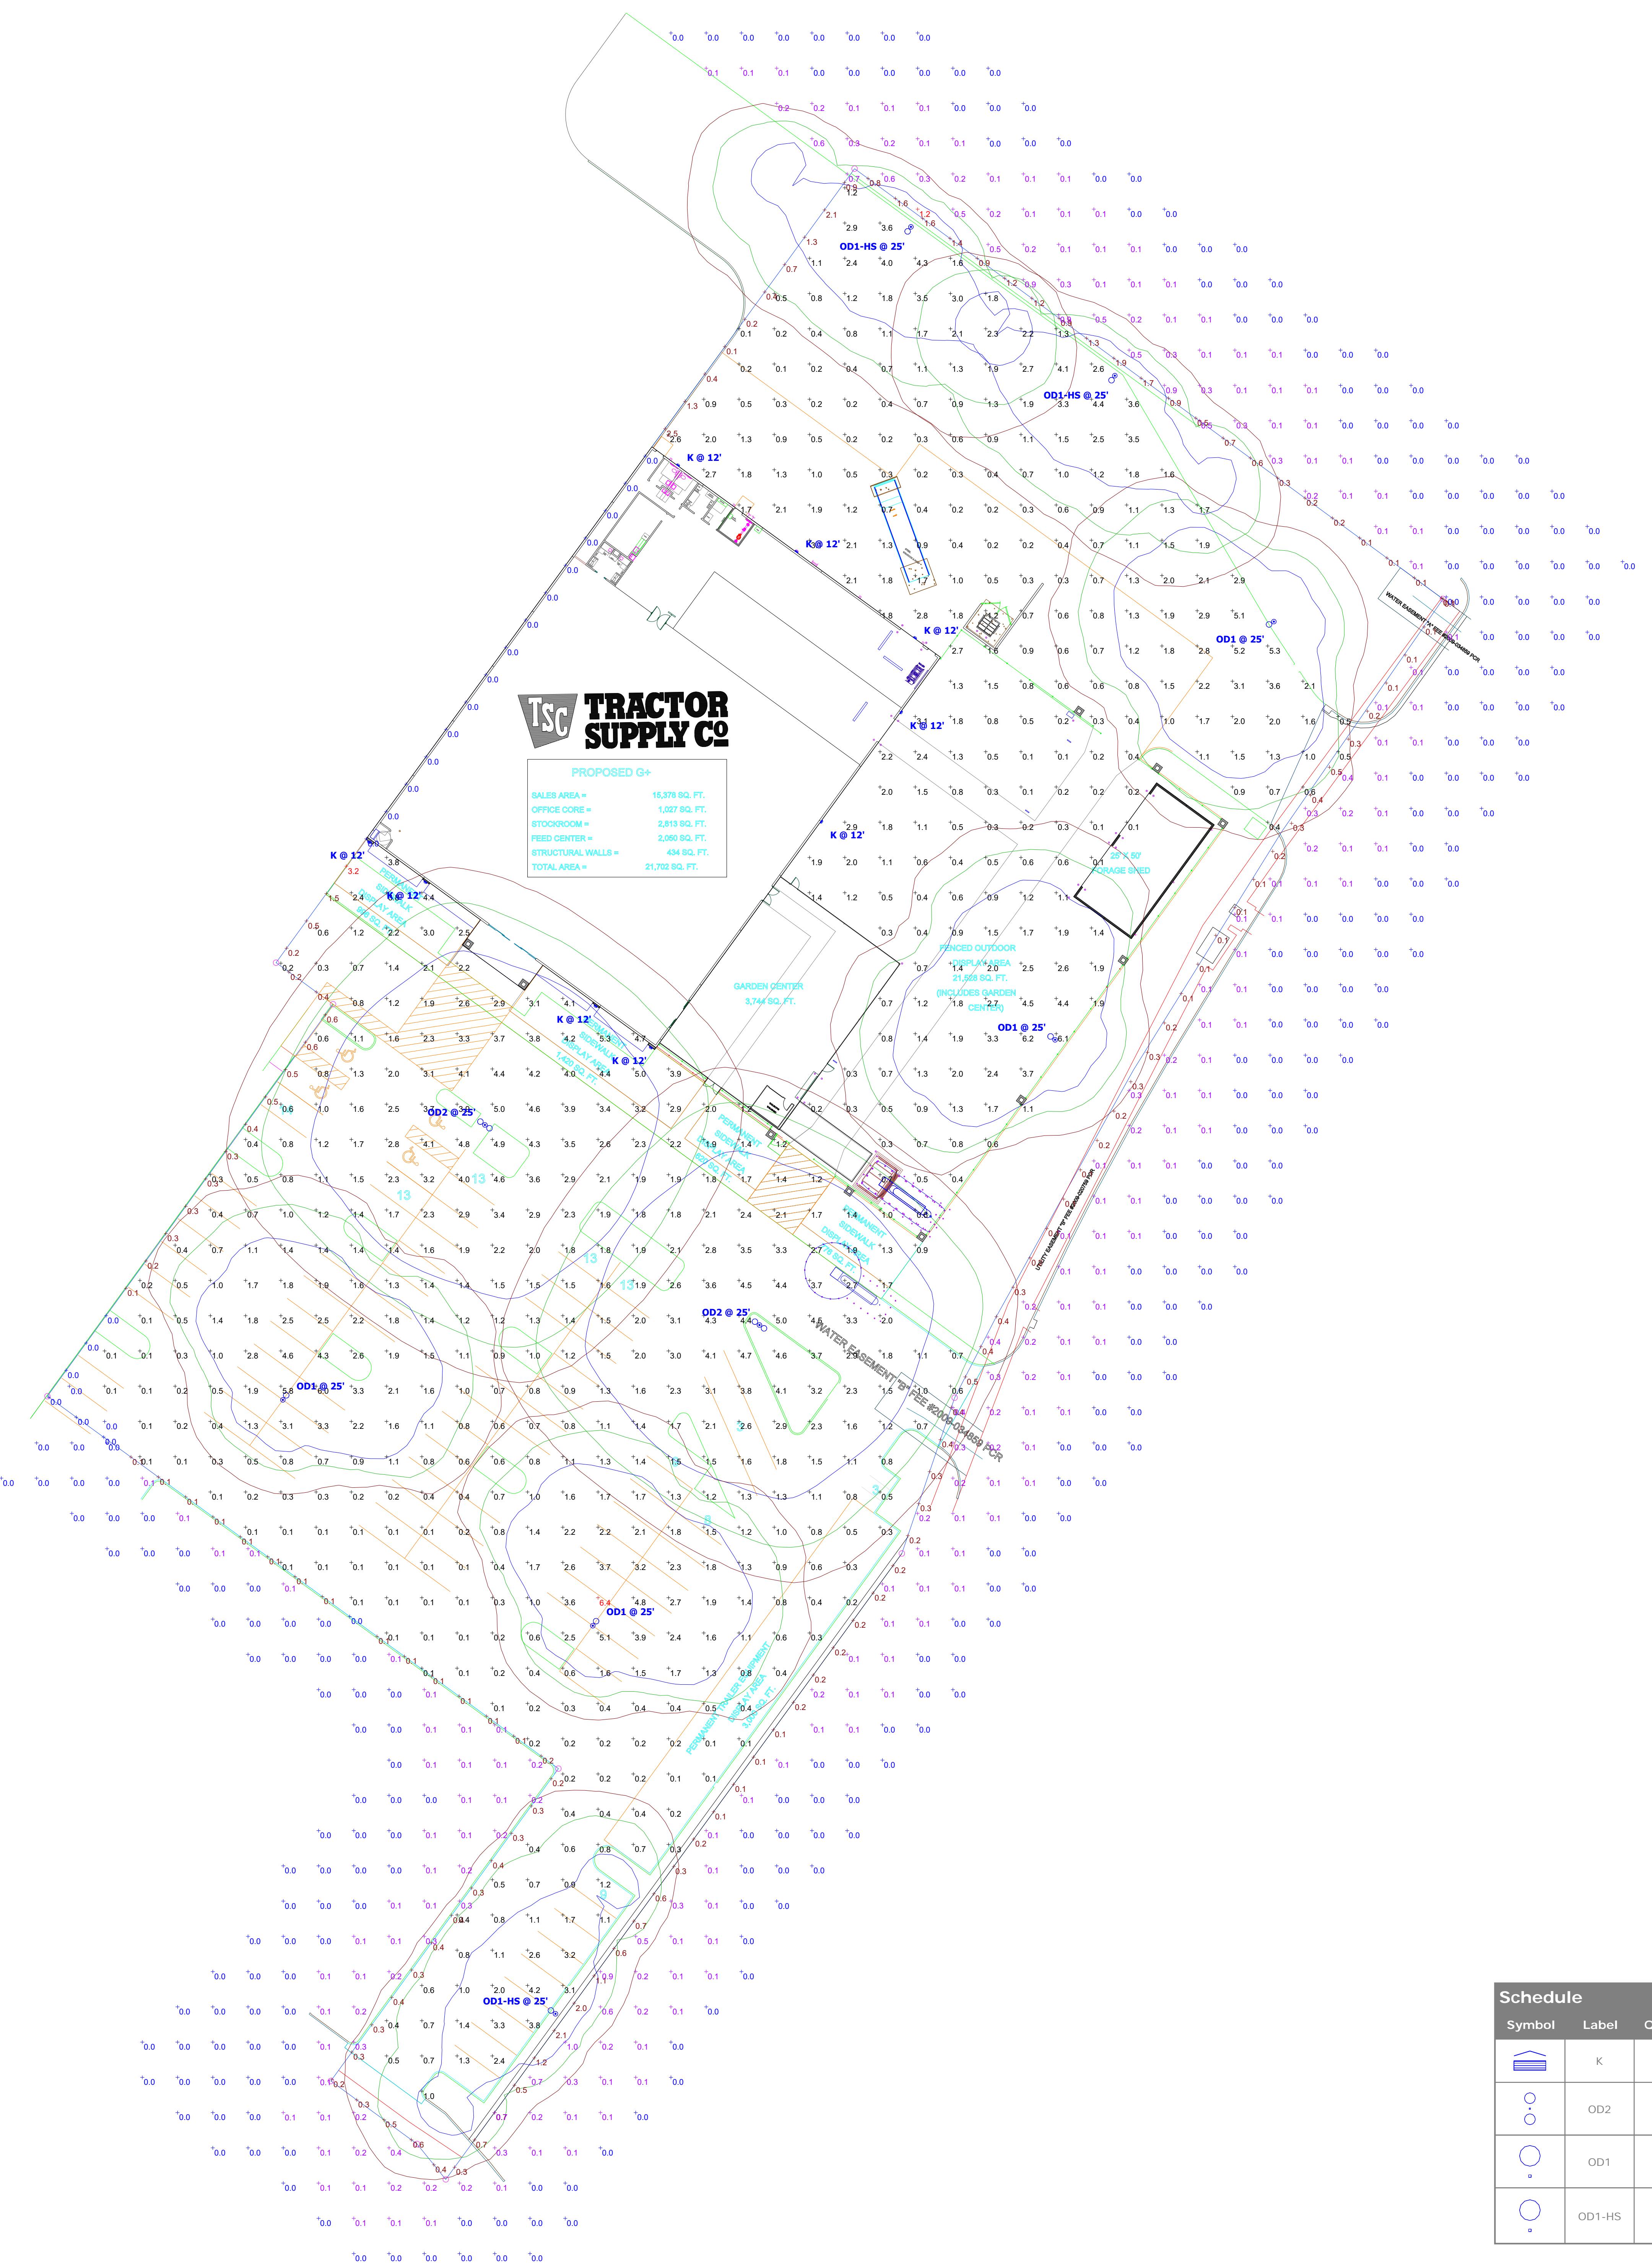

Statistics							
Description	Symbol	Avg	Max	Min	Max/Avg	Max/Min	Avg/Min
Parking Lot Light Levels	+	1.6 fc	6.4 fc	0.0 fc	4.00	N/A	N/A
Property Line Light Levels	+	0.4 fc	3.2 fc	0.0 fc	8.00	N/A	N/A
Light Spill Levels	+	0.1 fc	1.2 fc	0.0 fc	12.00	N/A	N/A

Symbol	Label	Quantity	Catalog Number	Description	Lamp	Wattage
	K	9	DSXW1-LED-10C-1000-50K-T3M-MVOLT-DDBXD	Lithonia DSXW1 Series Wall Mount LED Unit w/Type T3M Distribution (12ft. Fixture Mounting Height) FULL CUTOFF DESIGN	LED/5000K (FULL CUTOFF DESIGN)	38.8
	OD2	2	ODN-2-L-T5W-64LC-7-4K / VA110-L-D2	Double Head D180 Visionaire Lighting LLC Oden Series Architectural LED Area Unit w/Type T5W Distribution (22ft. Pole Height w/3ft. Concrete Base)	LED/4000K (FULL CUTOFF DESIGN) B4-U0-G2	280
	OD1	4	ODN-2-L-T4-64LC-7-4K / VA110-L-S1	Single Head Visionaire Lighting LLC Oden Series Architectural LED Area Unit w/Type T4 Distribution (22ft. Pole Height w/3ft. Concrete Base)	LED/4000K (FULL CUTOFF DESIGN) B3-U0-G3	140
	OD1-HS	3	ODN-2-L-T4-64LC-7-4K-CLS / VA110-L-S1	Single Head Visionaire Lighting LLC Oden Series Architectural LED Area Unit w/Type T4 Distribution (22ft. Pole Height w/3ft. Concrete Base) CUTOFF LOUVER SHIELD	LED/4000K (FULL CUTOFF DESIGN) B3-U0-G3 (CUTOFF LOUVER SHIELD)	140

**Designer**  
Adam Carrier  
**Date**  
11/29/2022  
**Scale**  
Not to Scale  
**Drawing No.**  
  
**Summary**