



ARCHICON
Architecture & Interiors, L.C.

5055 E WASHINGTON STREET
SUITE 200
PHOENIX, ARIZONA 85034
(602) 222-4266
FAX (602) 279-4305
www.ARCHICON.COM

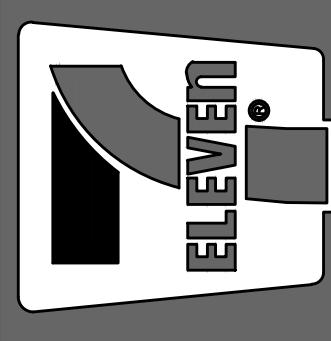

S.E.C. WEST HONEYCUTT ROAD AND NORTH WHITE AND PARKER ROAD
MARICOPA, ARIZONA 85139

WEST HONEYCUTT ROAD

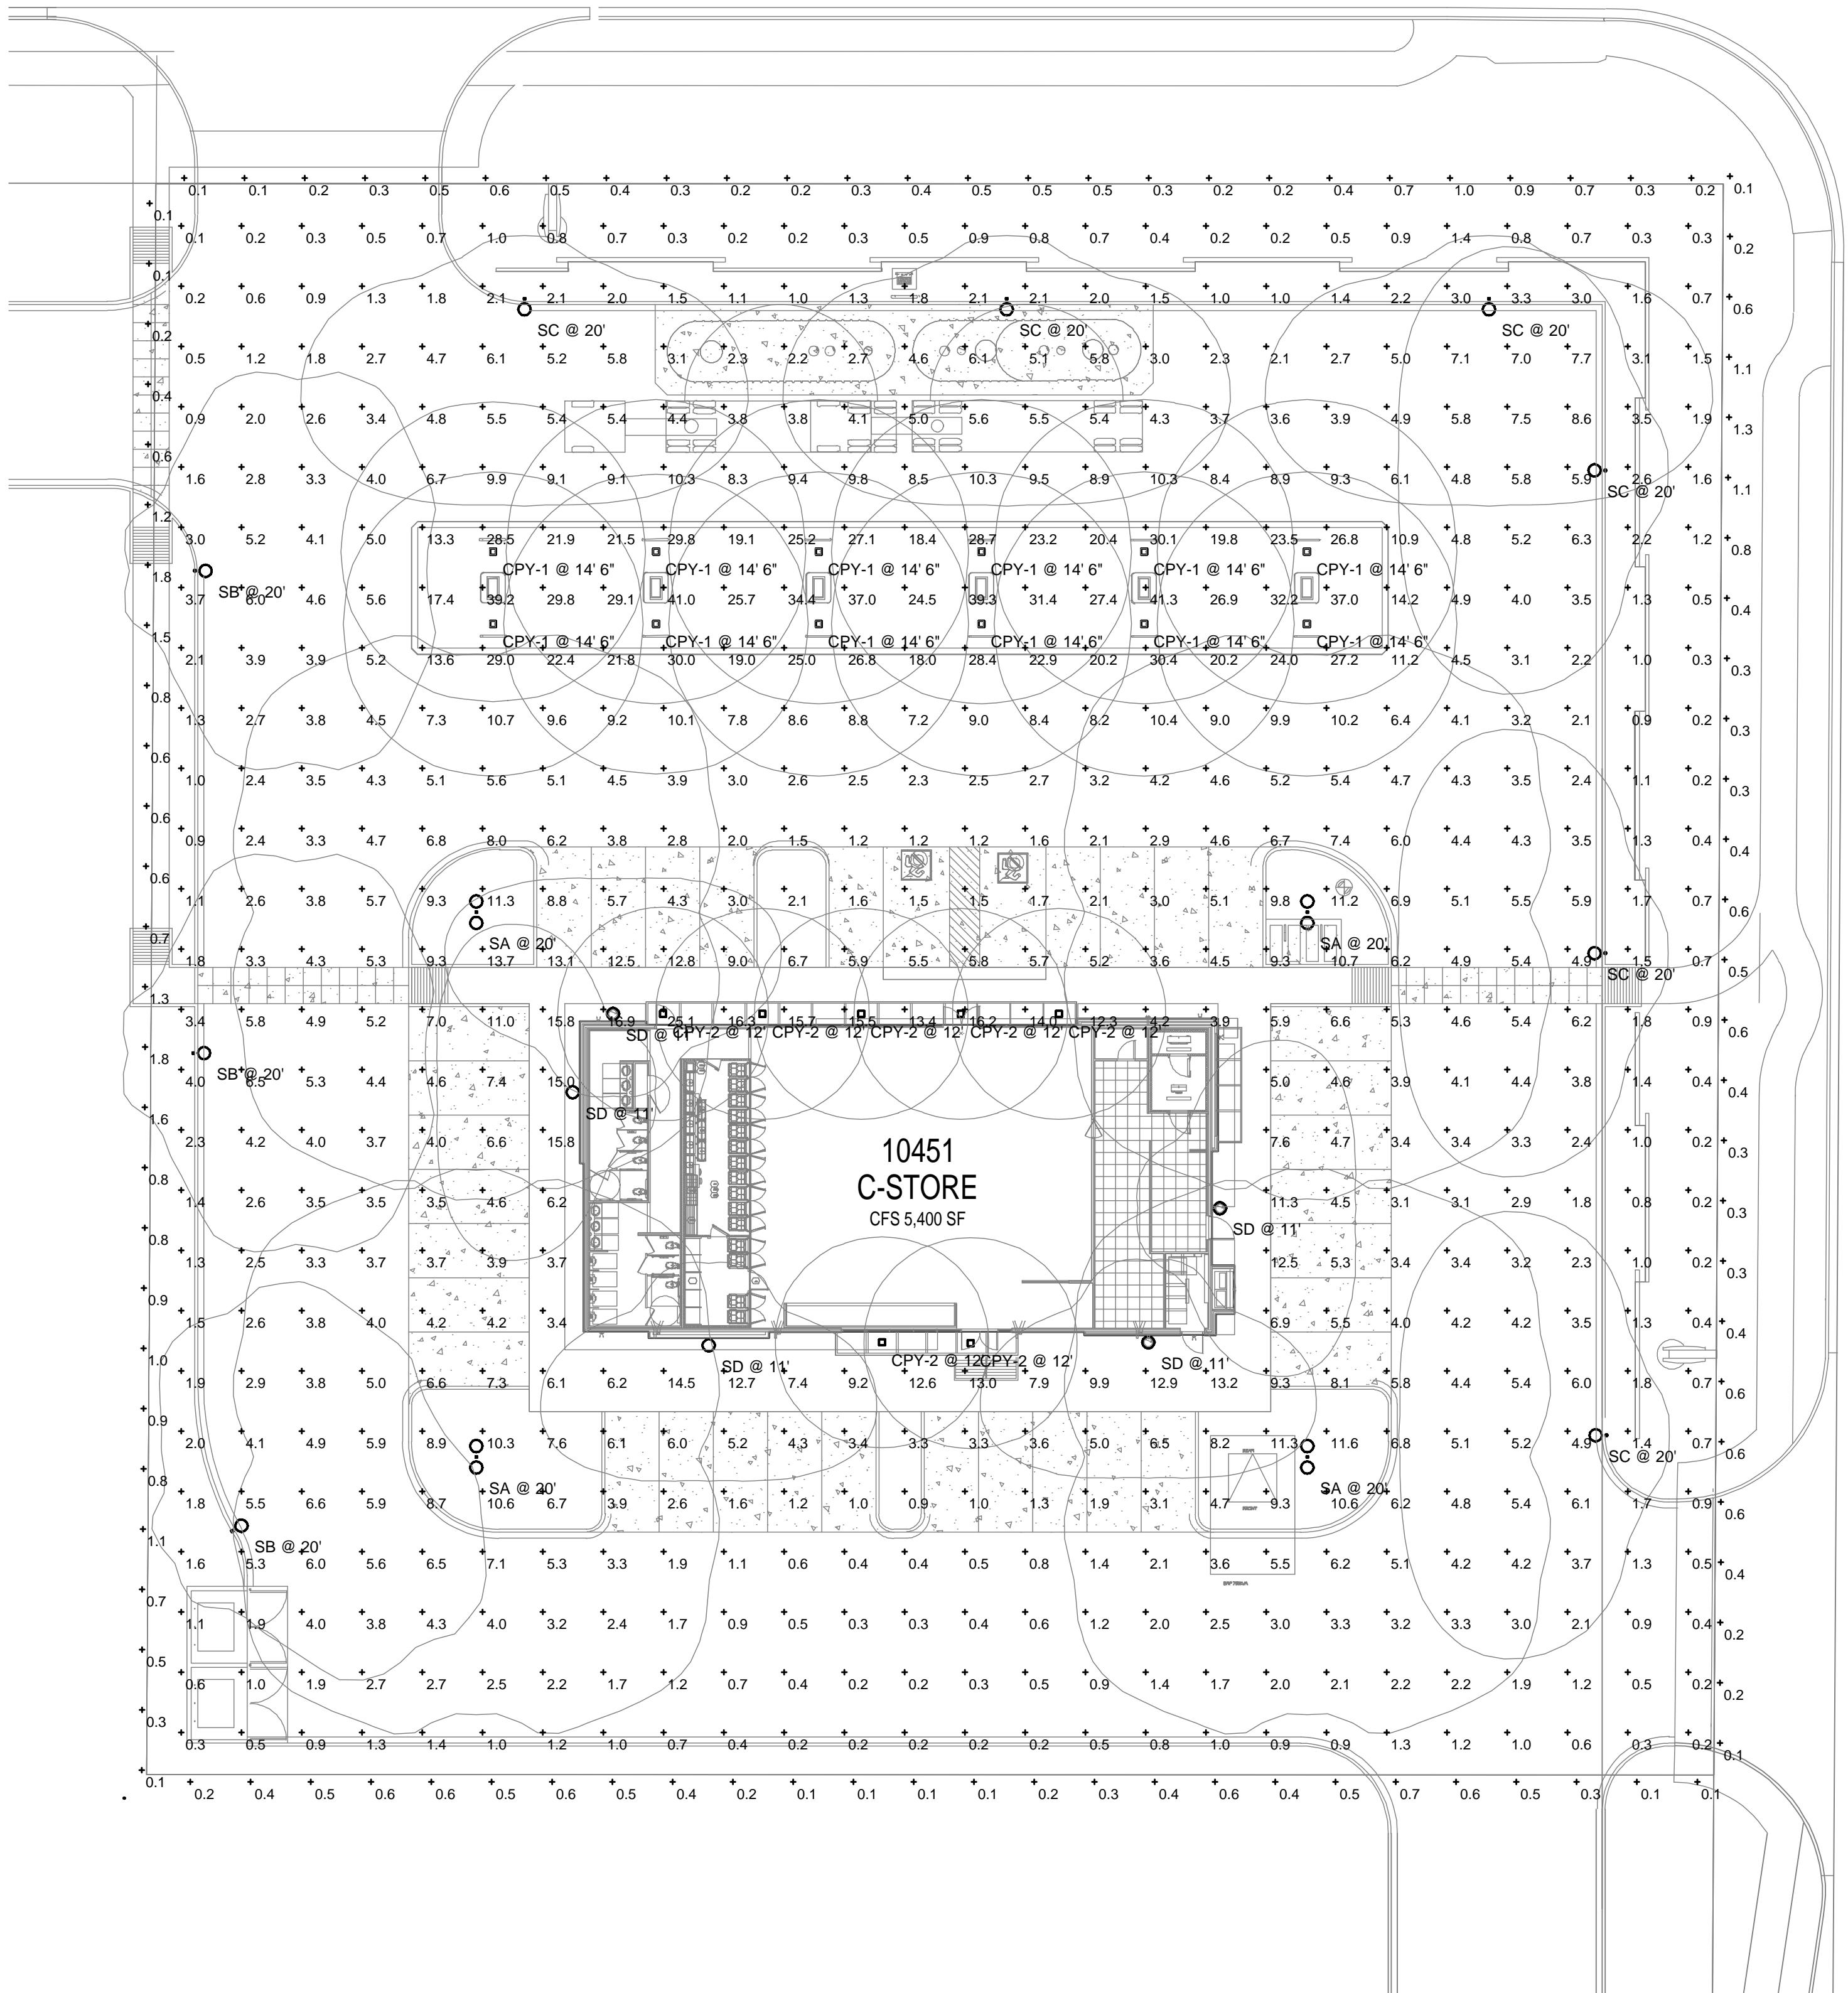

NORTH WHITE AND PARKER ROAD

Image		Symbol	Label	QTY	Manufacturer	Catalog	Description	Number Lamps	Lamp Output	LLF	Input Power
Image	Text										
○	SA	4	Visionaire Lighting LLC	ODN-2-L-T4-64LC-5-3K-	25 in D x 22.5 in H LED LUMINAIRE	1	12072	1	210		
○	SB	3	Visionaire Lighting LLC	ODN-2-L-T4-64LC-3-3K-	25 in D x 22.5 in H LED LUMINAIRE	1	8536	1	72		
○	SC	6	Visionaire Lighting LLC	ODN-2-L-T3-64LC-3-3K-	25 in D x 22.5 in H LED LUMINAIRE	1	9113	1	72		
○	SD	5	Visionaire Lighting LLC	ODN-2-L-T3-48LC-3-3K-	25 in D x 22.5 in H LED LUMINAIRE	1	6978	1	54		
□	CPY-1	12	Cree Lighting	CPY250-C-13L-50K7-F-UL-xx-xx-xxx	CONFIGURED FROM CPY250 Canopy Luminaire, 13L Lumen Package, 5700K, 70 CRI, Flat Lens, 120-277V	1	13749	1	86		
□	CPY-2	7	Cree Lighting	CPY250-C-4L-57K7-F-UL-xx-xx-xxx	CONFIGURED FROM CPY250 Canopy Luminaire, 13L Lumen Package, 5700K, 70 CRI, Flat Lens, 120-277V	1	4890	1	31		

Statistics					
Description	Symbol	Avg	Min	Max/Min	Avg/Min
Site / Boundary Line	+	0.5 fc	0.1 fc	18.0:1	5.0:1
Site	+	0.6 fc	0.1 fc	413.0:1	18.0:1

7-ELEVEN

JOB NO:	2522510-03	
PROJECT MGR:	GWJ	
DRAWN BY:	GWJ	
CHECKED BY:	GWJ	
NO.	REVISION	DATE

SHEET TITLE:
PHOTOMETRIC
SITE PLAN


PRELIMINARY NOT FOR
CONSTRUCTION

PH-101



SCALE: 1" = 20'-0"


ISSUE DATE: -

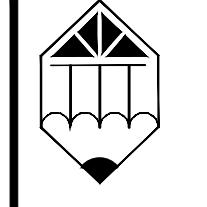

ARCHICON

Architecture & Interiors, L.C.

5055 E WASHINGTON STREET
SUITE 200
PHOENIX, ARIZONA 85034
(602) 222-4266
FAX (602) 279-4305
www.ARCHICON.com

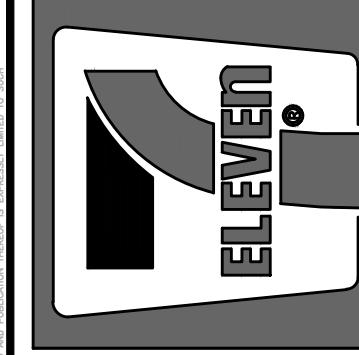

ELEVATE

ELEVATE